


VICINITY MAP

LOCATE HYDRANT SO THAT DRIVE IS NOT BLOCKED WHEN CONNECTED.  
 ( SEE DETAILS #2 & #3 )  
 CONNECTION IS ON THE SIDE OF THE TRUCK

PROVIDE PROJECT NAME  
 PROJECT ADDRESS, CITY,  
 ASSESSORS PARCEL NUMBER  
 APPLICANT NAME  
 APPLICANT PHONE  
 PERMIT NO.

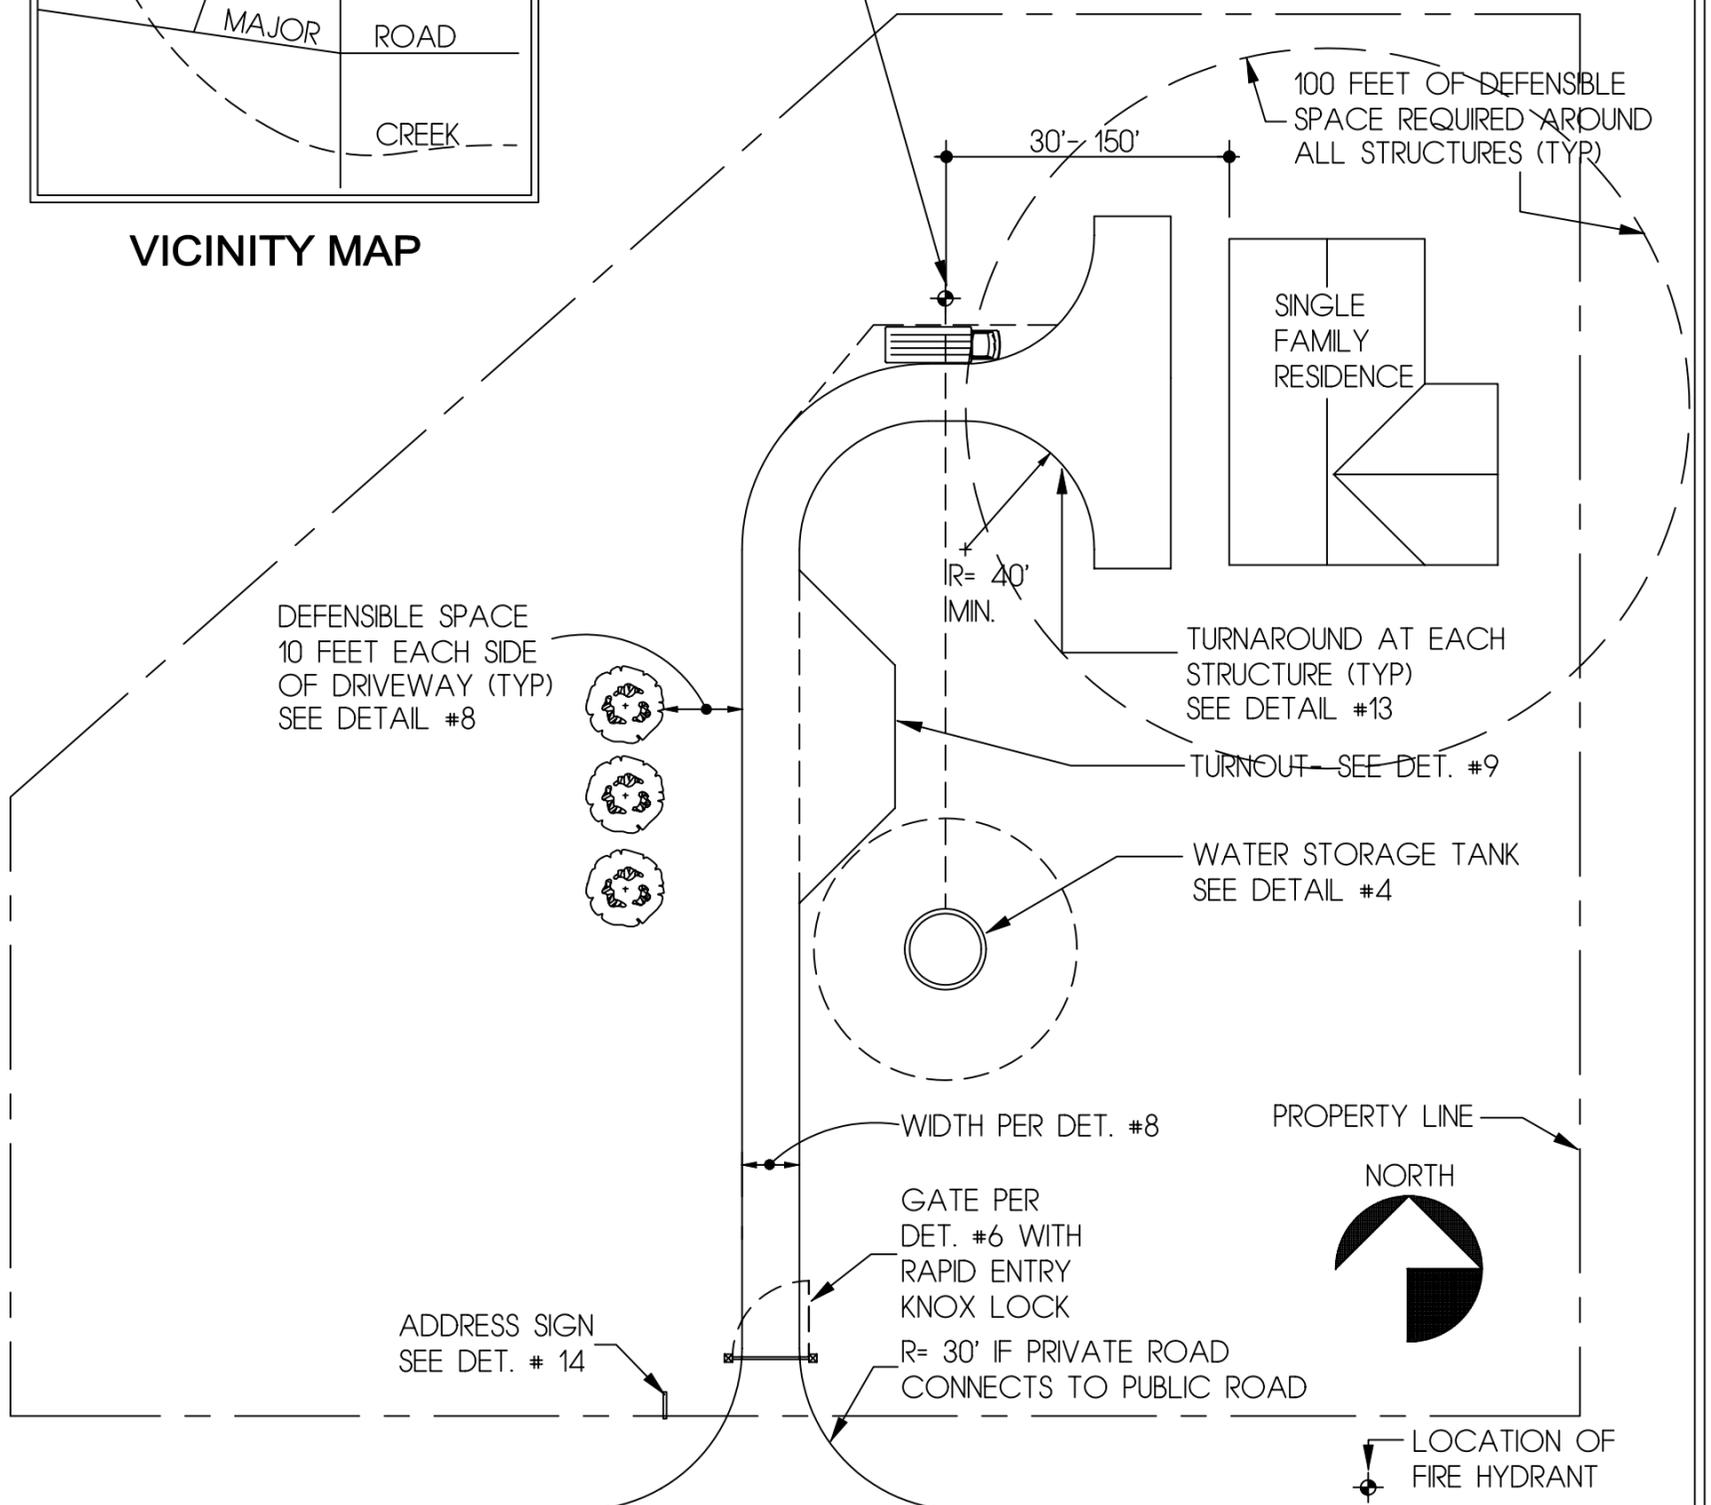

ROAD NAME

RESIDENTIAL SAMPLE SITE PLAN

**CAL FIRE**  
 Napa County Fire Department  
 1199 BIG TREE ROAD  
 ST. HELENA, CALIFORNIA 94574  
 OFFICE PHONE (707) 967-1419 FAX (707) 967-1474

FIRE SAFE STANDARDS

1/50" = 1-0"	<b>1</b>
SCALE	
--	
REVISION DATE	DRAWING NO. 1